



Notes:
 -This drawing must be read in conjunction with all other drawings, details, Schedules & specifications of the same revision
 -This layout and the information contained within is a private property of Architectonic Studio Ltd and may not be used, transmitted or reproduced in whole or in part without the prior written consent of Architectonic Studio Ltd.
 -All dimensions to be checked on site prior to commencement of works. In case of inconsistencies, report immediately and seek confirmation.
 -All building work to be completed to the satisfaction of the Local Authority Building Control Officer in accordance with the current Building Regulations and as such additional unforeseen building works may be required on site.
 -Smoke alarms and fire equipment to be checked by specialist
 -Applicant to make sure that smoke and carbon detectors are located in the space where indicated in layout prior to any use these plans.

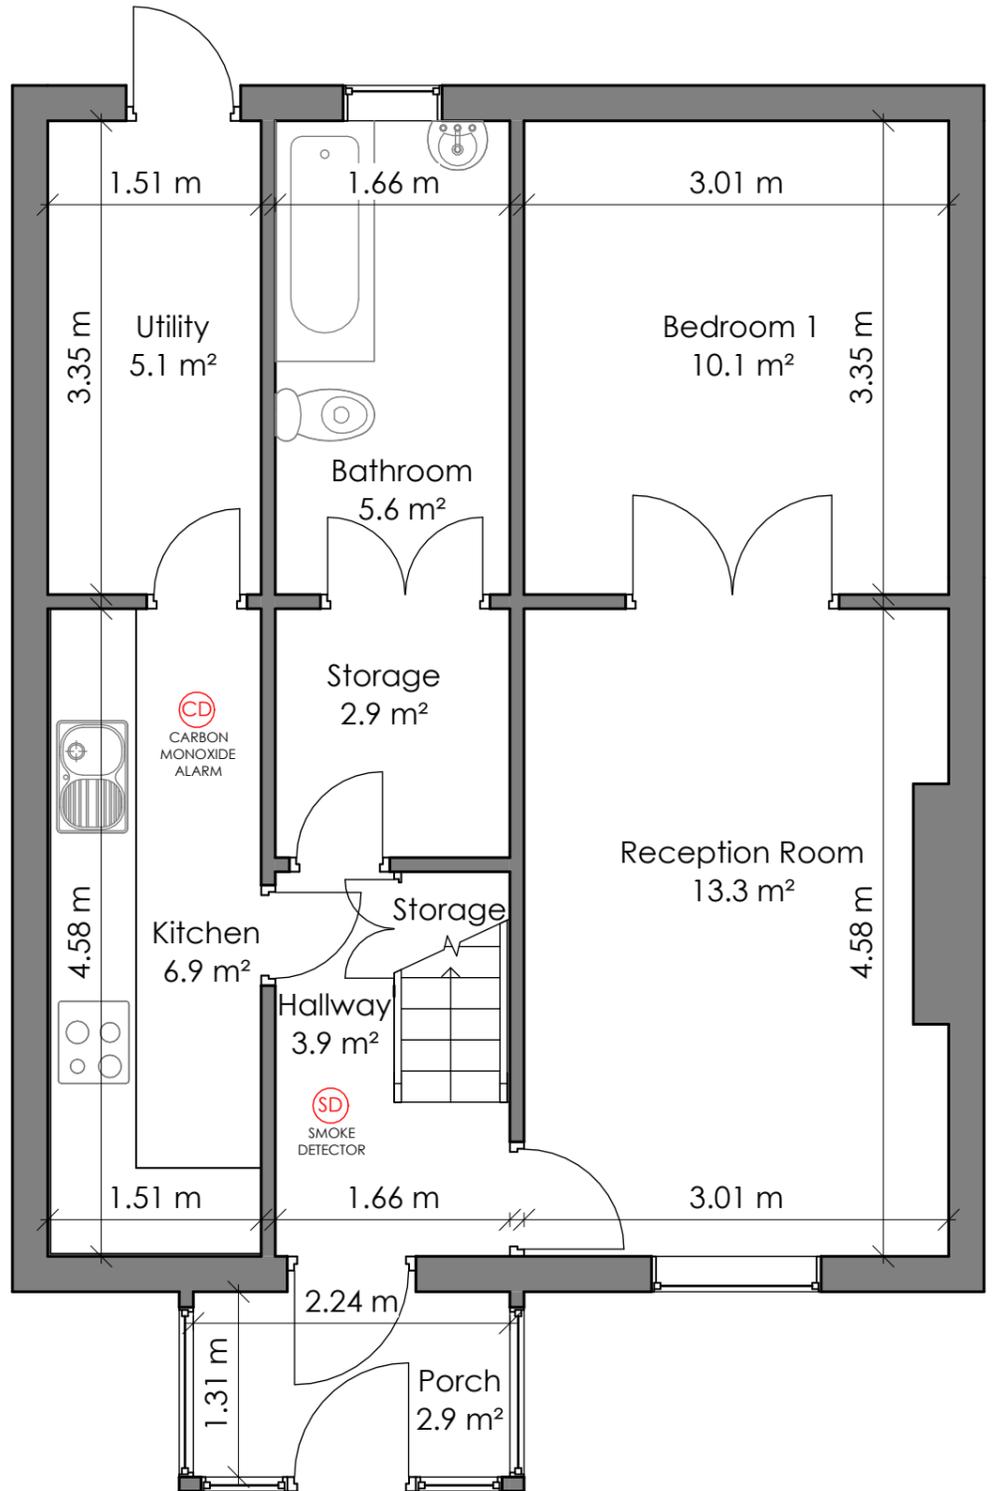

① A14-00 - Ground Floor Plan
1 : 50

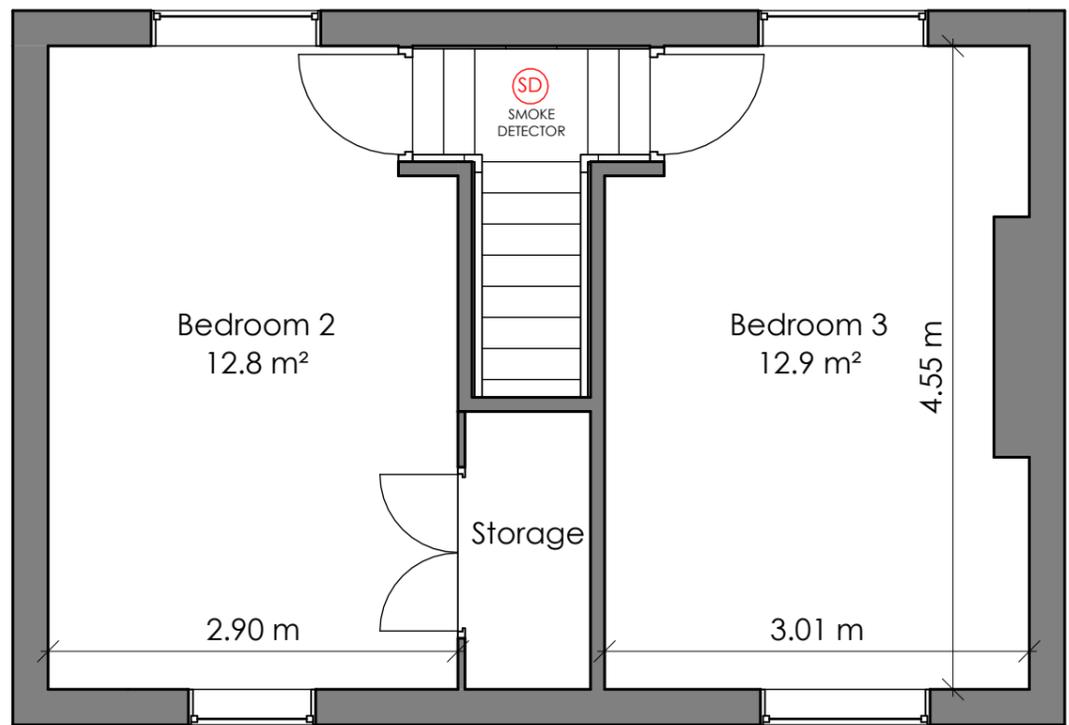

② A14-01 - First Floor Plan
1 : 50



LEGEND

- (HD) HEAT DETECTOR
- (SD) SMOKE DETECTOR
- (CD) CARBON MONOXIDE ALARM

Rev	Description	Date
P02	First Issue	23/06/2023

Address: 5 Cornwall Avenue, Southall, UB1 2SZ

Drawing Title: Ground & First Floor Layouts

Date: June 2023 | Designed by: AS

Status: For Approval

Scale @ A3 1 : 50

A14